


Sunset 5


DATE:	1-29-26
JOB #	2610A

SHEET:
A2

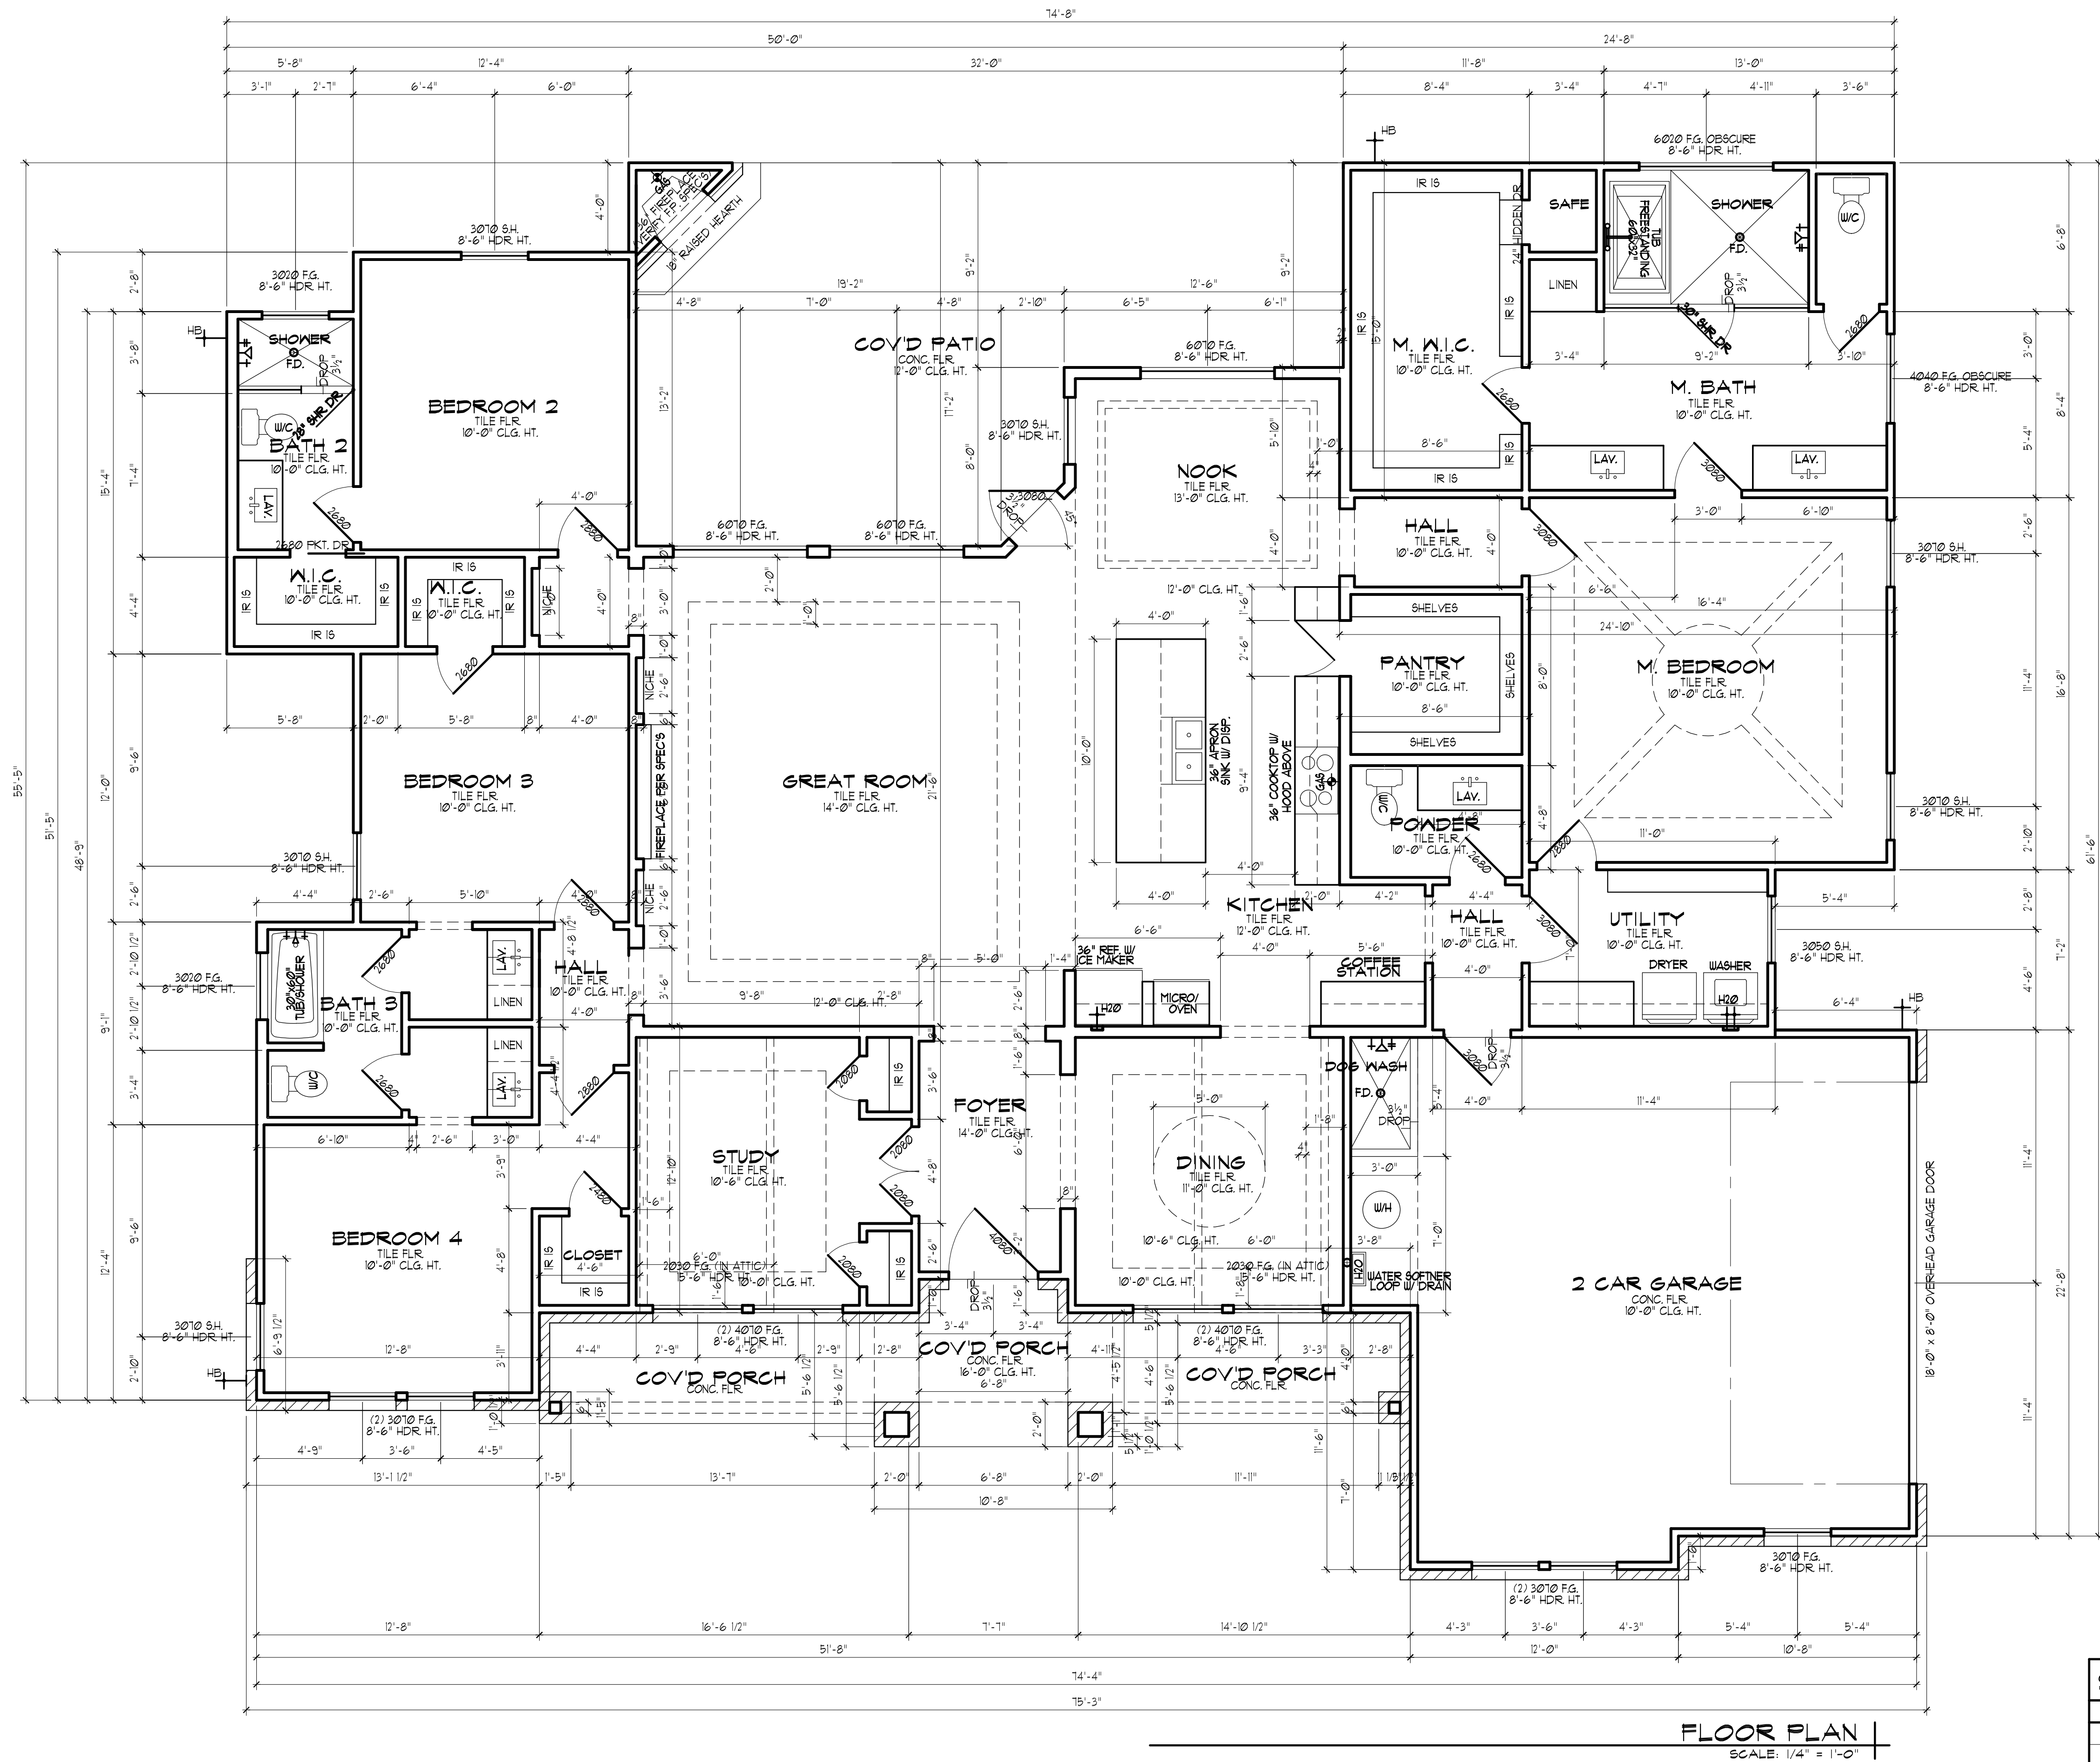

SQUARE FOOTAGES	
TOTAL LIVING	2,925. SQ. FT.
2 CAR GARAGE	559. SQ. FT.
COVD' PORCH	214. SQ. FT.
COVD' PATIO	440. SQ. FT.
MASONRY LUG	32. SQ. FT.
TOTAL FRAME	4,126. SQ. FT.
TOTAL SLAB	4,110. SQ. FT.

Sunset 5

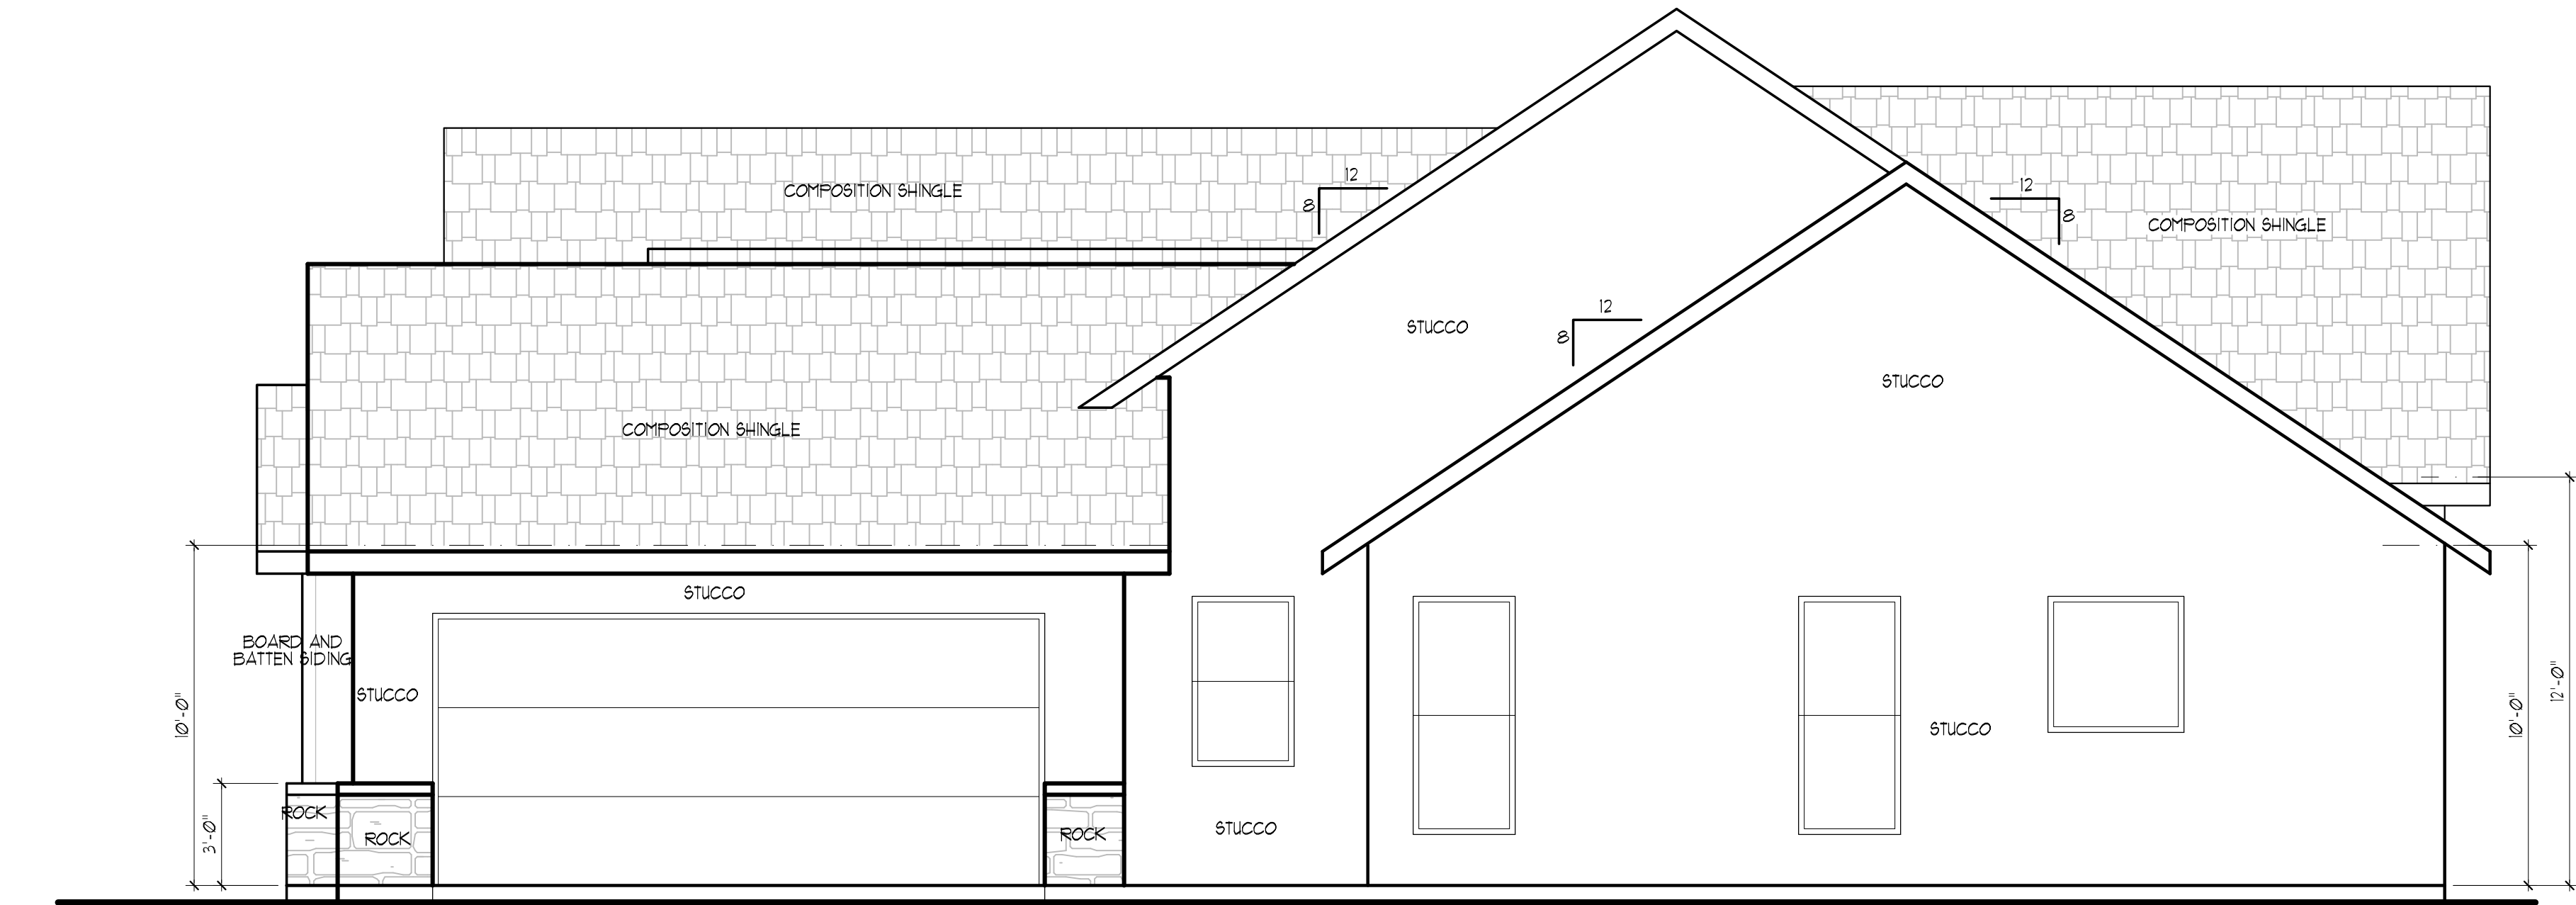

REAR ELEVATION

SCALE: 1/4" = 1'-0"



 
 
FRONT ELEVATION

SCALE: 1/4" = 1'-0"


DATE: REVISIONS:

DATE: 1-29-26
JOB #: 2610A

SHEET:
A3

[illegible]

Sunset 5

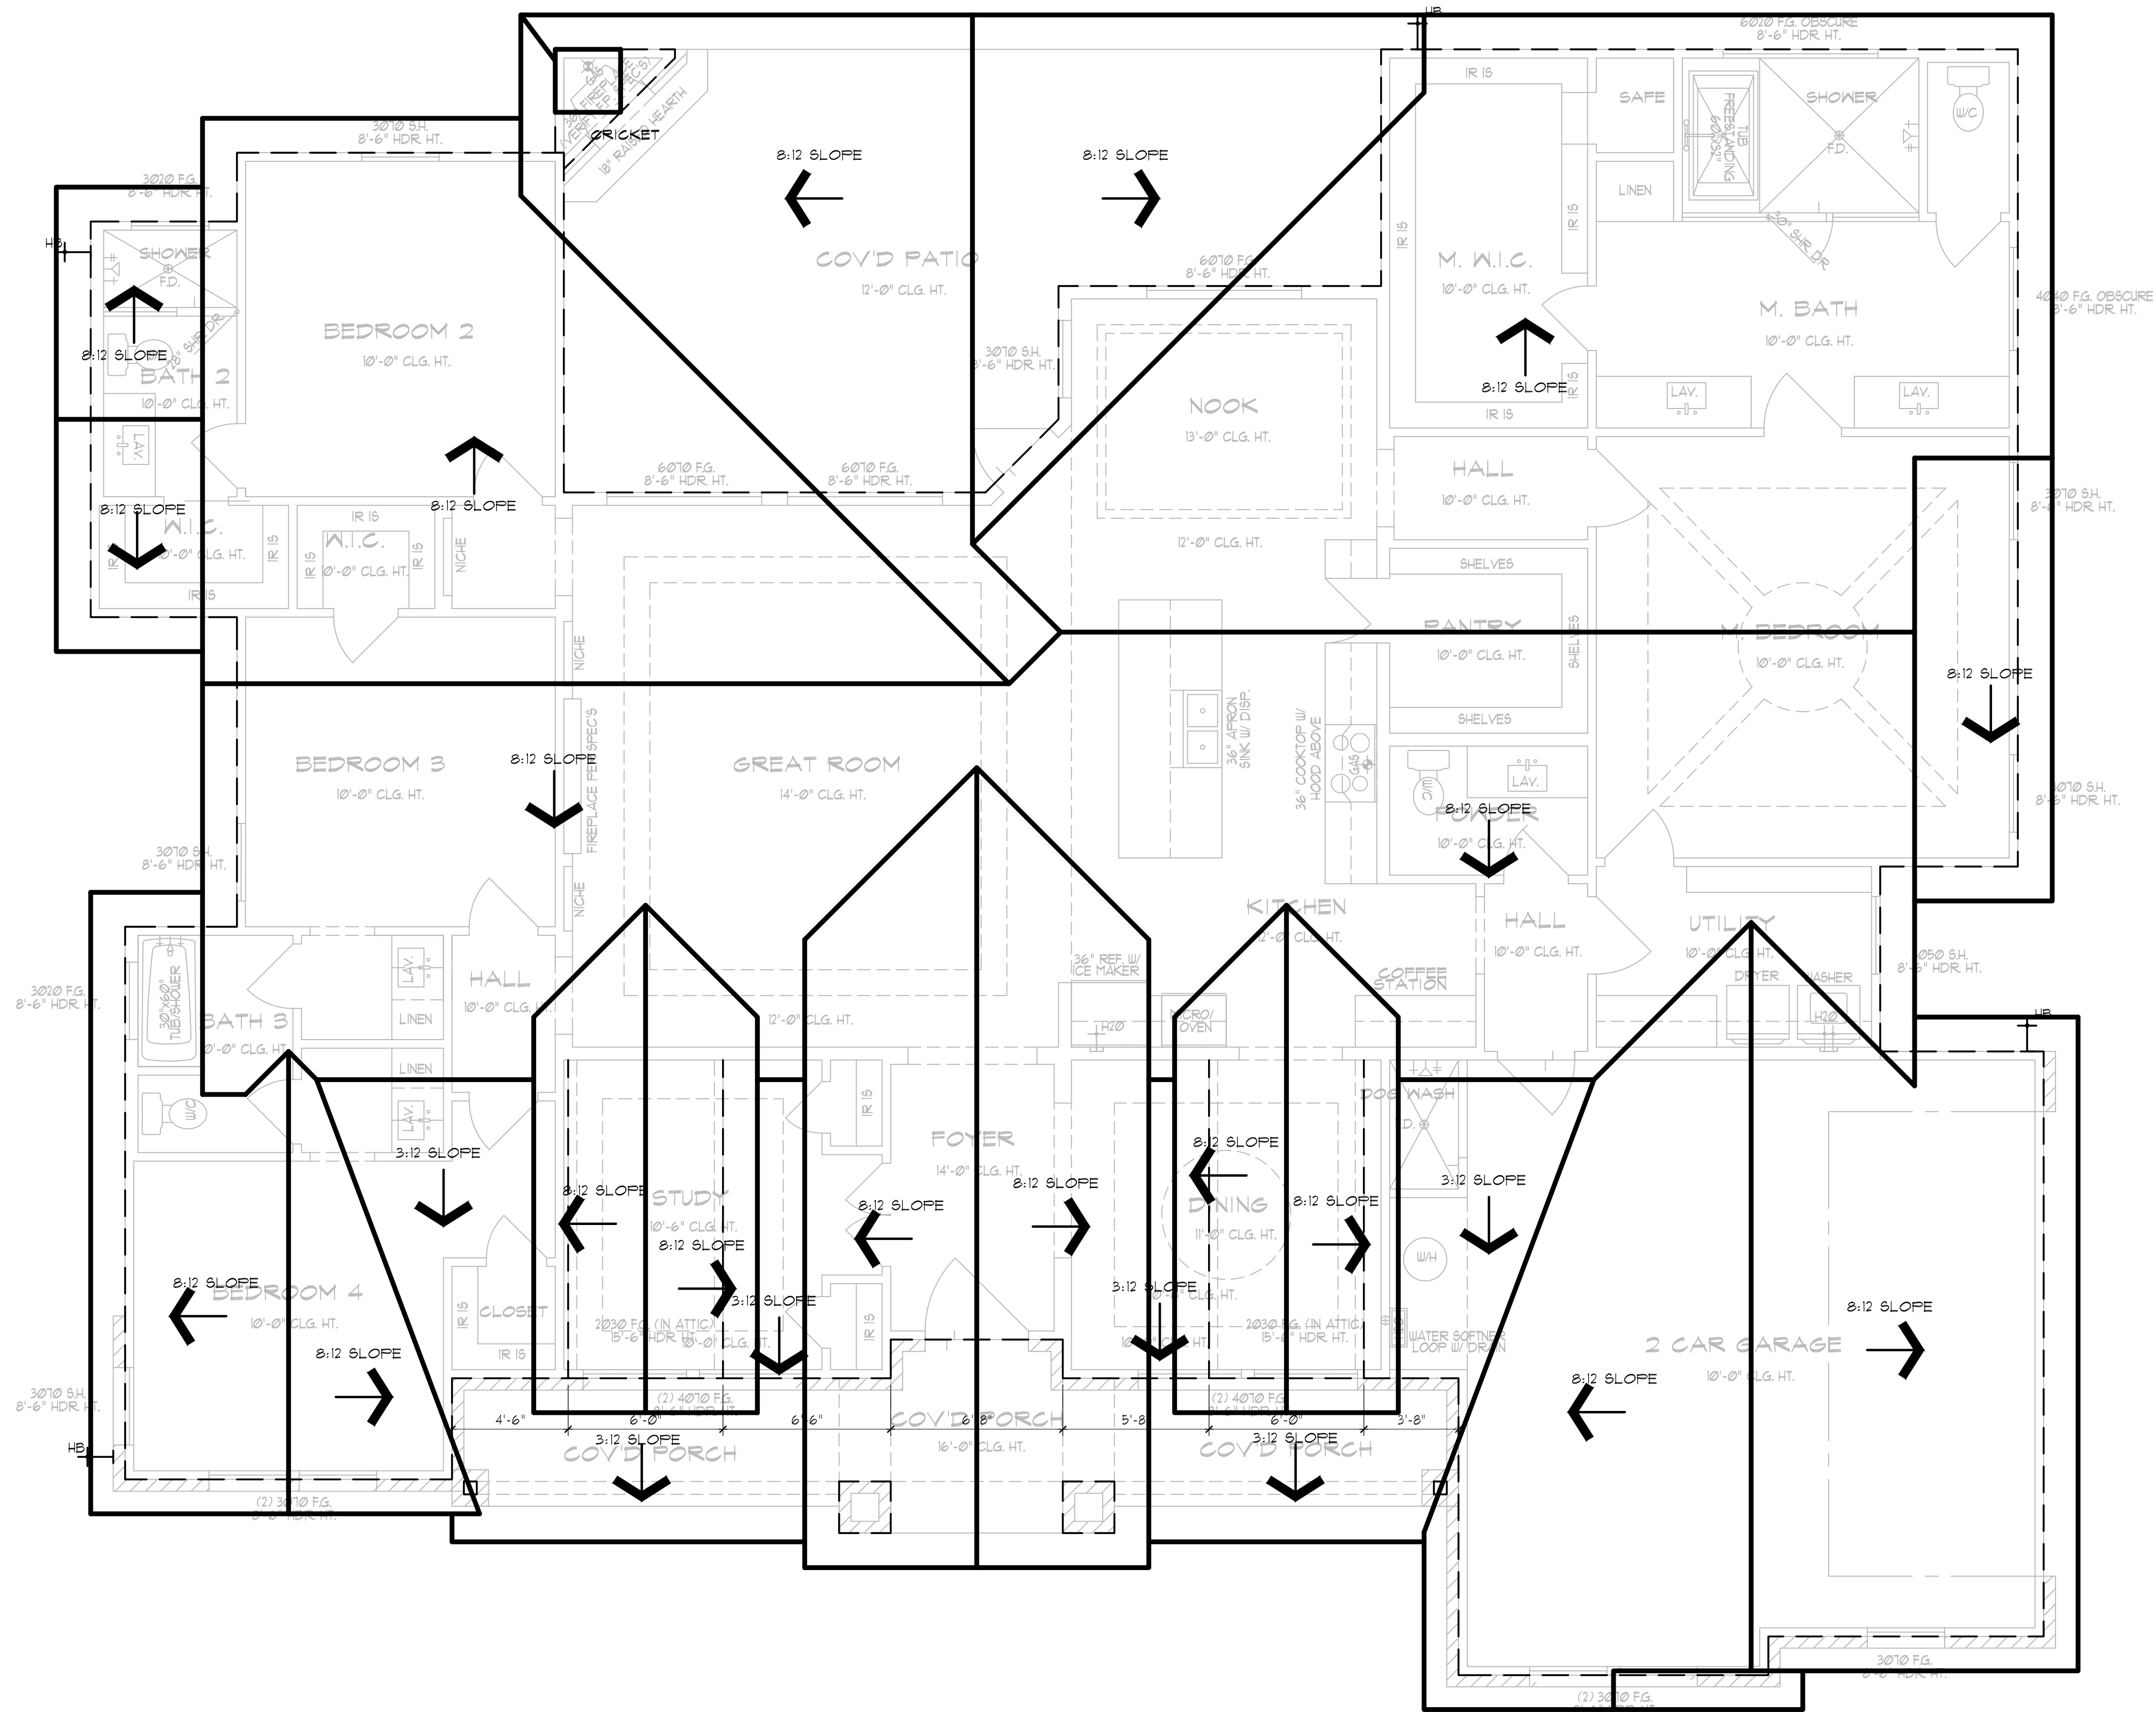

ROOF PLAN |
SCALE: 1/4" = 1'-0"

DATE:	REVISIONS:			

DATE: 1-29-26
JOB #: 2610A

SHEET:
A4

Sunset 5

DATE:	REVISIONS:


DATE: 1-29-26
JOB #: 2610A

SHEET:
E1

ELECTRICAL SYMBOLS					
	SWITCH		4" DUPLEX OUTLET RAISED TO HEIGHT INDICATED		SOFFIT LIGHT
	DIMMER SWITCH		WATERPROOF DUPLEX OUTLET		FENDANT LIGHT
	THREE WAY SWITCH		OUTLET FOR ELEC. GAR. DR. OPNR		SURFACE MOUNT CLG. LIGHT FIXTURE
	FOUR WAY SWITCH		TWO DUPLEX (4 OUTLETS)		WALL MOUNT LIGHT FIXTURE
	DUPLEX OUTLET		JBOX DUPLEX OUTLET		RECESSED CEILING VAPOR PROOF LIGHT FIXTURE
	DUPLEX OUTLET WITH GROUND FAULT INTERRUPTER		FLOOR OUTLET		HANGING FIXTURE
	WATER PROOF / GFCI		CARBON MONOXIDE		EYEBALL/SPOT LIGHT FIXTURE
	EAVE OUTLET/ SOFFIT OUTLET		SMOKE ALARM		TRACK-MOUNT FIXT.
	CEILING OUTLET		COMBINATION SMOKE ALARM / CARBON MONOXIDE		UNDER CABINET LIGHT
	220 VOLT DUPLEX OUTLET		ABOVE CABINET LIGHT		
	40AMP / 240V DEDICATED EV RECEPTACLE				

PLUMBING SYMBOLS					
	WATER HEATER		HOT & COLD WATER		THERMOSTAT
	WATER SOFTNER		STUB OUT WATER LINE HOT & COLD		COMBINATION FIXT. LIGHT, VENT, HEAT
	SHOWER HEAD		WATER LINE		COMBINATION FIXT. LIGHT, VENT
	HOSE BIB/FAUCET		FLOOR DRAIN		FLOOD LIGHT
	ICE MAKER IN REF.		GAS KEY (ON/OFF) VALVE		CEILING FAN W/LT BLK & WIRE FOR CLG. FAN
	WATER SOFTNER LOOP W/ DRAIN		GAS LINE		SPRINKLER SYSTEM
	WATER HEATER		POT FILLER		
	WATER SOFTNER				
	SOFTENER LOOP WITH DRAIN				
	PLUMB FOR SOFTENER LOOP WITH DRAIN				

LOW VOLTAGE SYMBOLS					
	DATA / TEL. OUTLET		SPEAKER		
	DATA OUTLET		CAMERA		
	TELEVISION OUTLET		SPEAKER WIRE		
	ETHERNET/CABLE OUTLET		GARAGE DR. KEY PAD		
	TELEPHONE OUTLET		GARAGE DR. OPENER		
	PUSH BUTTON DOORBELL				
	CHIMES				

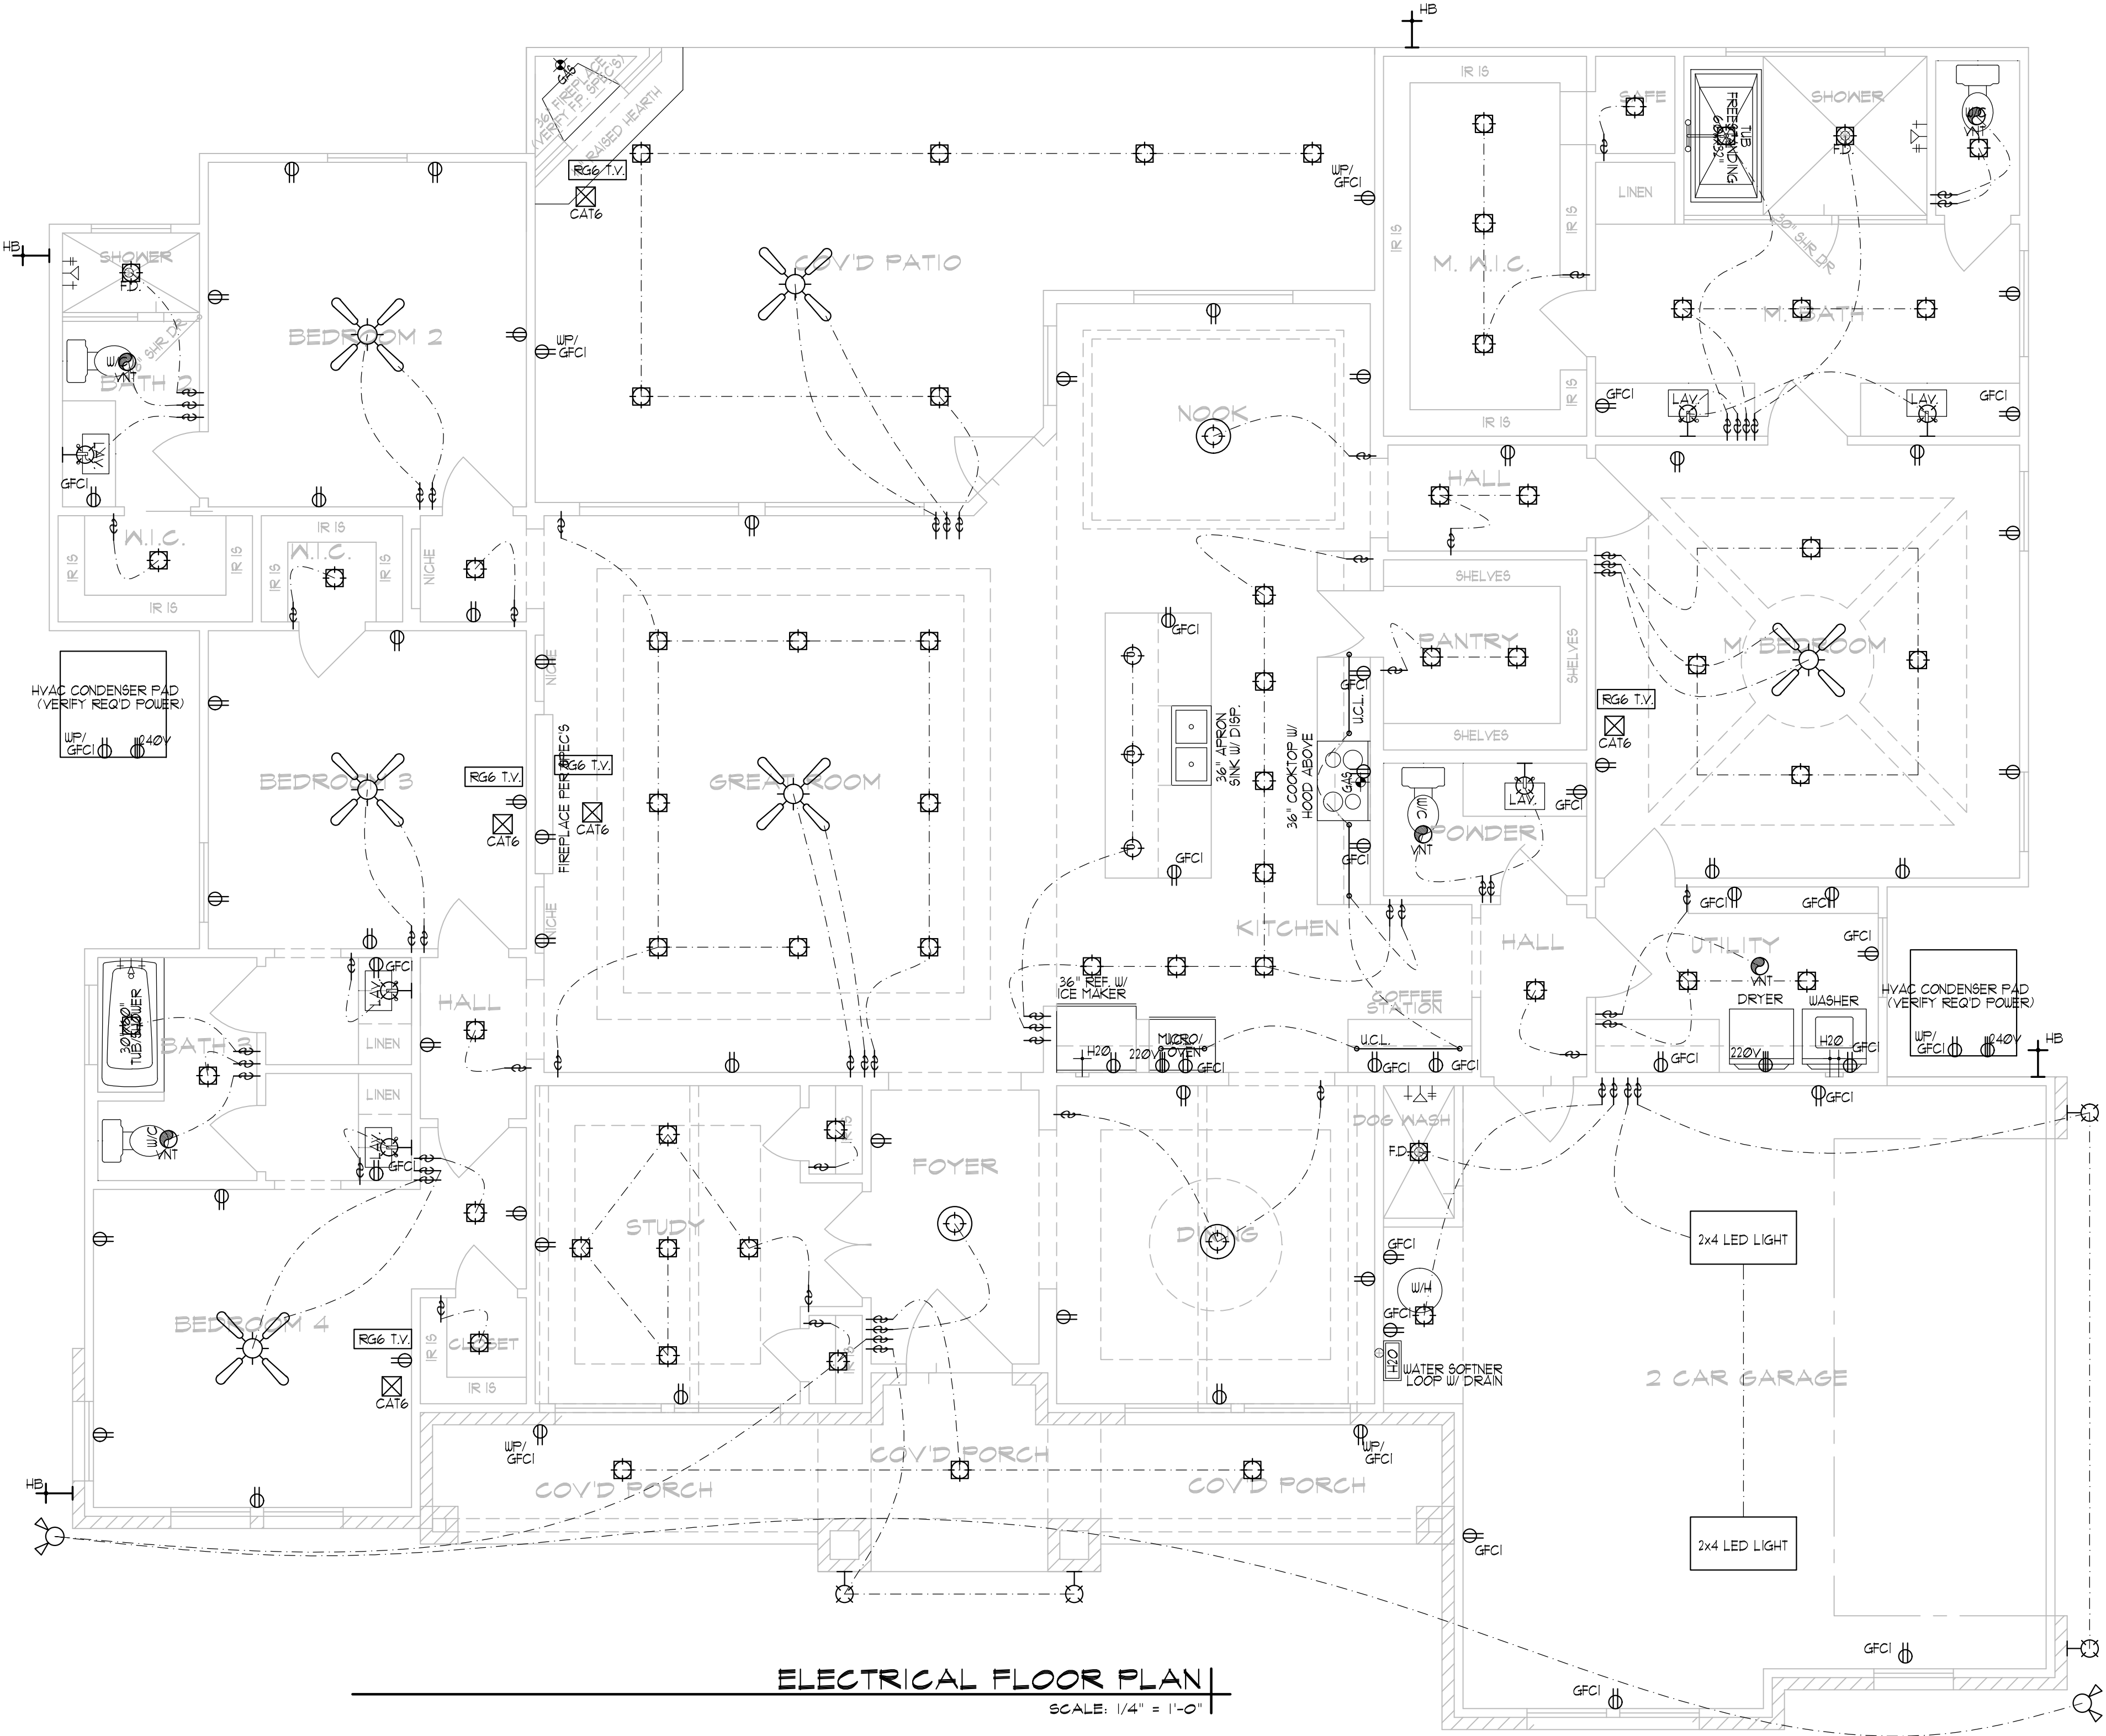

ELECTRICAL FLOOR PLAN
SCALE: 1/4" = 1'-0"